NOTES & LEGEND - INTERIOR ELEVATIONS

1. GRAPHIC REPRESENTATION OF MATERIALS AND/OR FIXTURES MAY NOT BE TO SCALE.
2. SEE FLOOR PLANS AND FINISH PLANS/SCHEDULES FOR TYPICAL ROOM FINISHES NOT SHOWN IN INTERIOR ELEVATIONS. 3. ANY FURNITURE SHOWN IS FOR REFERENCE ONLY AND INDICATES PLACEHOLDER FUNISHINGS.


 ANY FORNITURE SHOWN IS FOR REFERENCE ONLY AND INDICATES PLACEHOLDER FUNISHINGS.
 FURNITURE TO BE SELECTED, PURCHASHED AND INSTALLED BY THE OWNER UNLESS
OTHERWISE NOTED.
 FOR EQUIPMENT INFORMATION AND LAYOUTS - REFER TO EQUIPMENT PLAN SHEETS AND
EQUIPMENT SCHEDULE SHEETS.
 UPPER CABINETS ARE FOR ADULT STAFF ONLY IN CLASSROOMS INTENDED FOR AGES 5-8 AND 7. SEE ACCESSIBILITY SHEET A03.01 FOR PLUMBING FIXTURE HEIGHTS AND MOUNTING HEIGHT INFORMATION.

RICE/ERGUSMILLER

ARCHITECTURE INTERIORS PLANNING VIZLAB 275 FIFTH STREET, SUITE 100 BREMERTON, WA 98337 360-377-8773


RFMARCH.COM




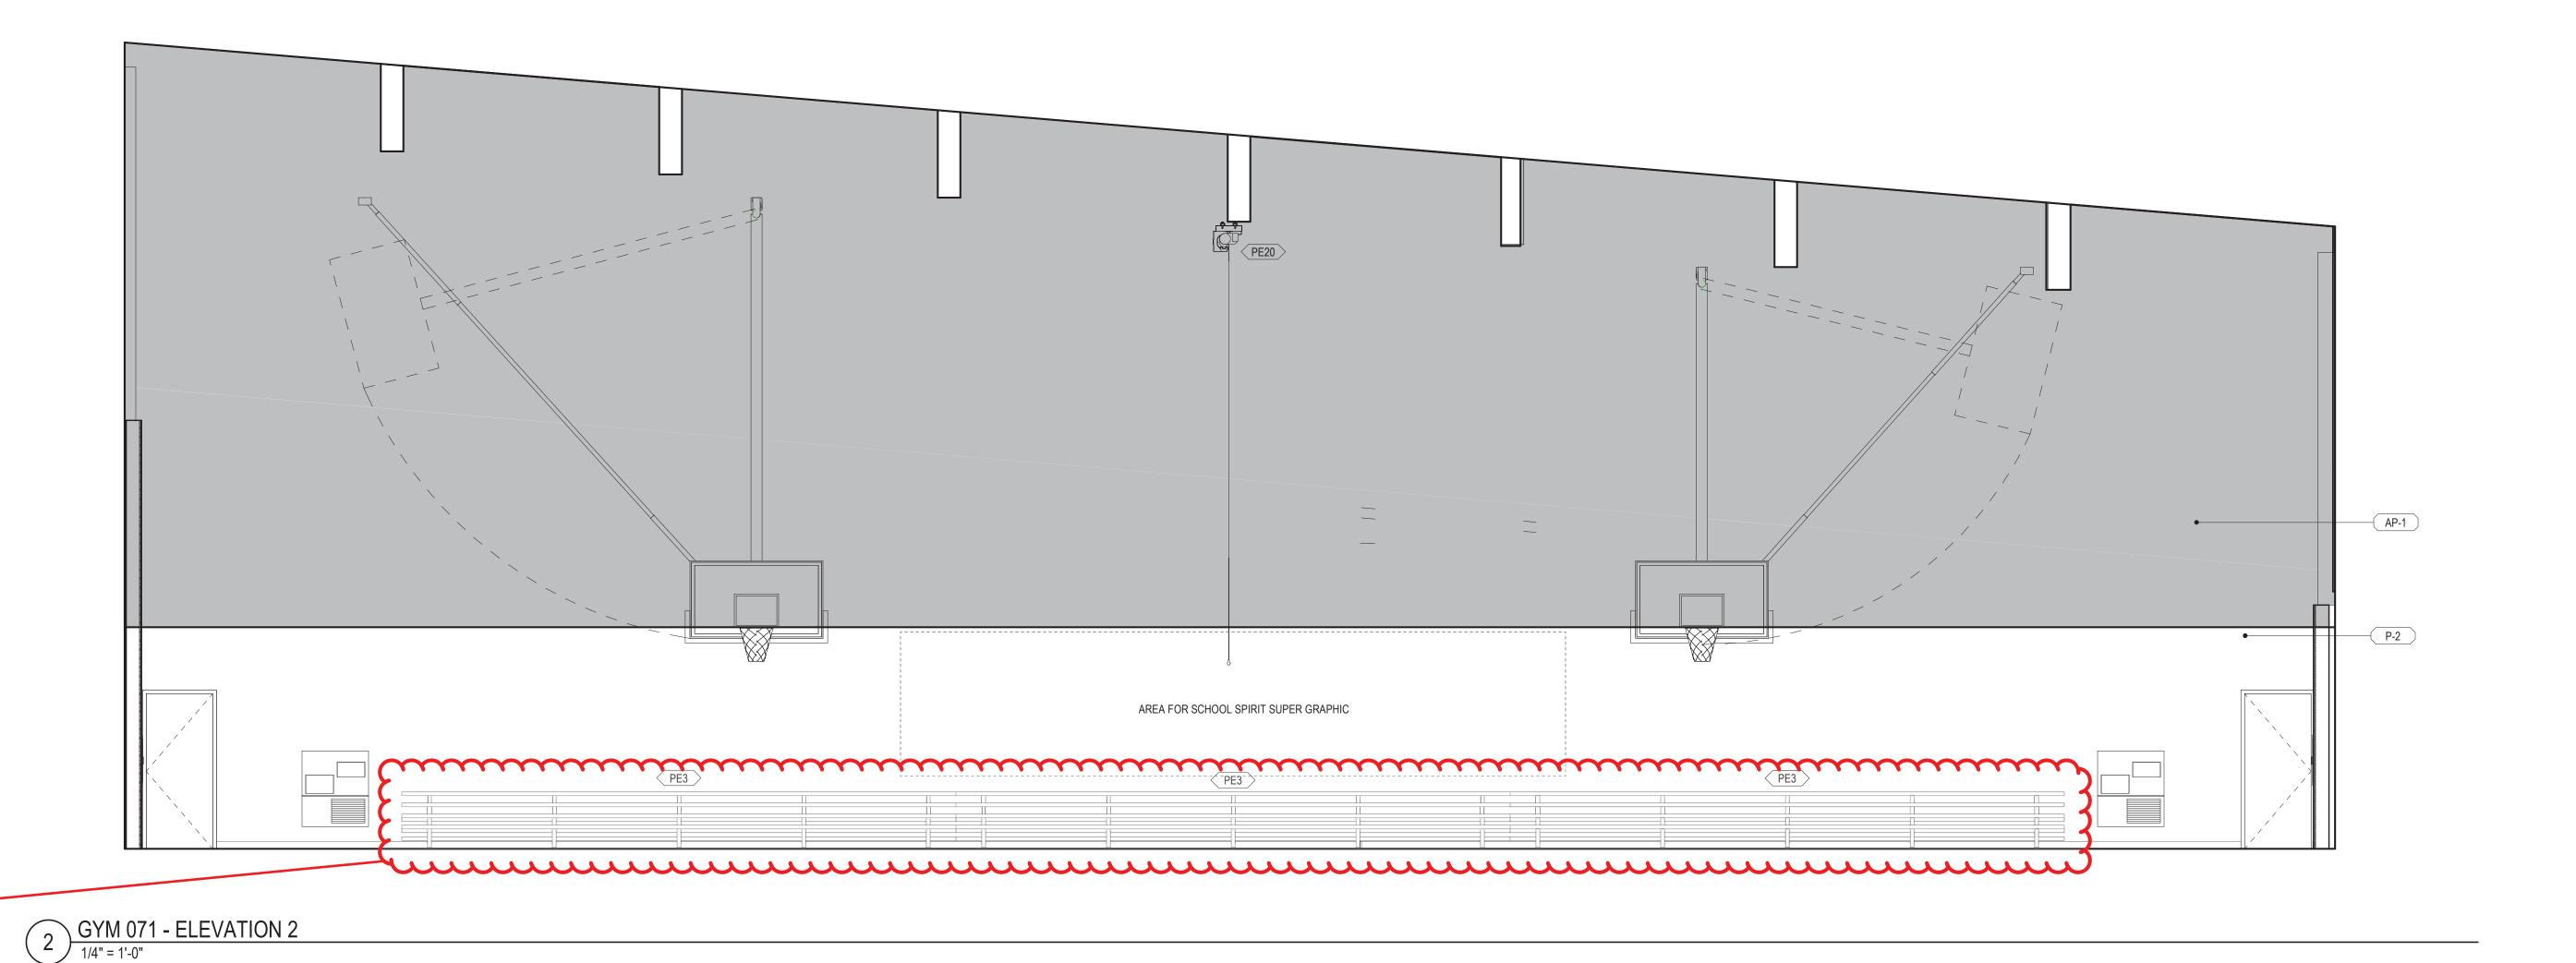

Reference QTS RFI 190 -Added aisle to bleachers per BIA comments

Also Reference QTS RFI 138 - Aisles & Row Spaces of Telescoping Bleachers

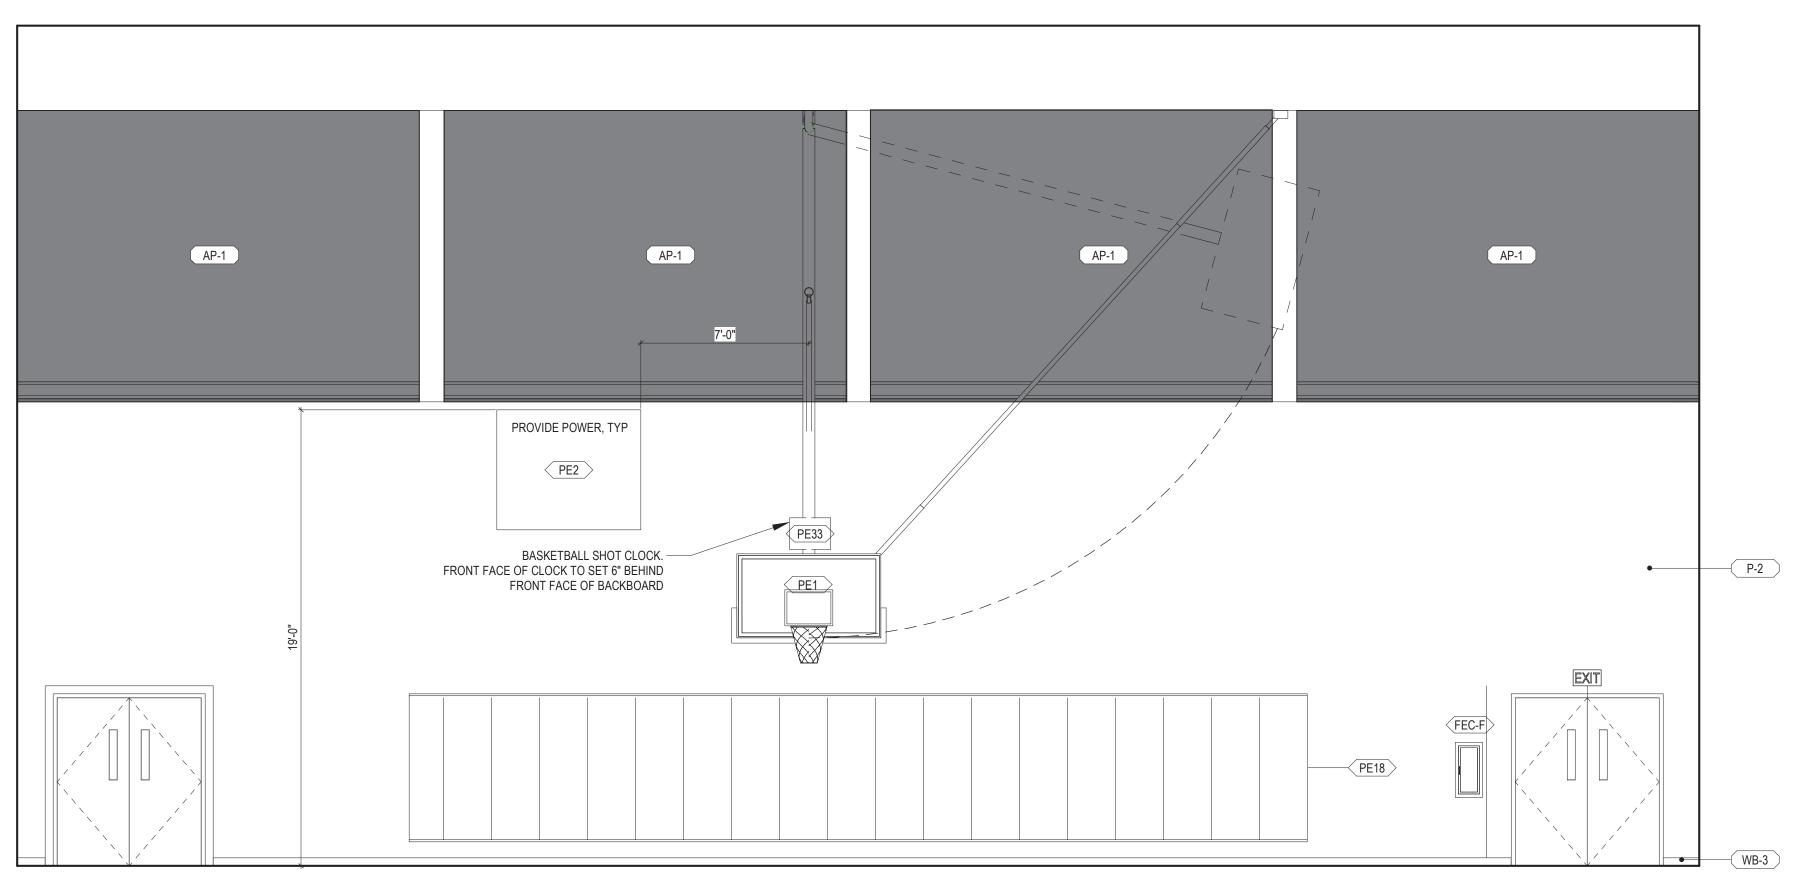

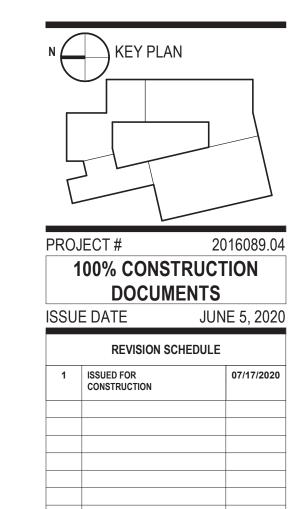

INTERIOR ELEVATIONS

A70.04

GYM 071 - ELEVATION 1

1/4" = 1'-0"

1. GRAPHIC REPRESENTATION OF MATERIALS AND/OR FIXTURES MAY NOT BE TO SCALE.
2. SEE FLOOR PLANS AND FINISH PLANS/SCHEDULES FOR TYPICAL ROOM FINISHES NOT SHOWN IN INTERIOR ELEVATIONS.
3. ANY FURNITURE SHOWN IS FOR REFERENCE ONLY AND INDICATES PLACEHOLDER FUNISHINGS.
4. FURNITURE TO BE SELECTED, PURCHASHED AND INSTALLED BY THE OWNER UNLESS

OTHERWISE NOTED.


5. FOR EQUIPMENT INFORMATION AND LAYOUTS - REFER TO EQUIPMENT PLAN SHEETS AND EQUIPMENT SCHEDULE SHEETS.

6. UPPER CABINETS ARE FOR ADULT STAFF ONLY IN CLASSROOMS INTENDED FOR AGES 5-8 AND


9-12 YRS.
7. SEE ACCESSIBILITY SHEET A03.01 FOR PLUMBING FIXTURE HEIGHTS AND MOUNTING HEIGHT INFORMATION.


ARCHITECTURE INTERIORS PLANNING VIZLAB 275 FIFTH STREET, SUITE 100 BREMERTON, WA 98337 360-377-8773 RFMARCH.COM

GREGORY A. BELDING STATE OF WASHINGTON

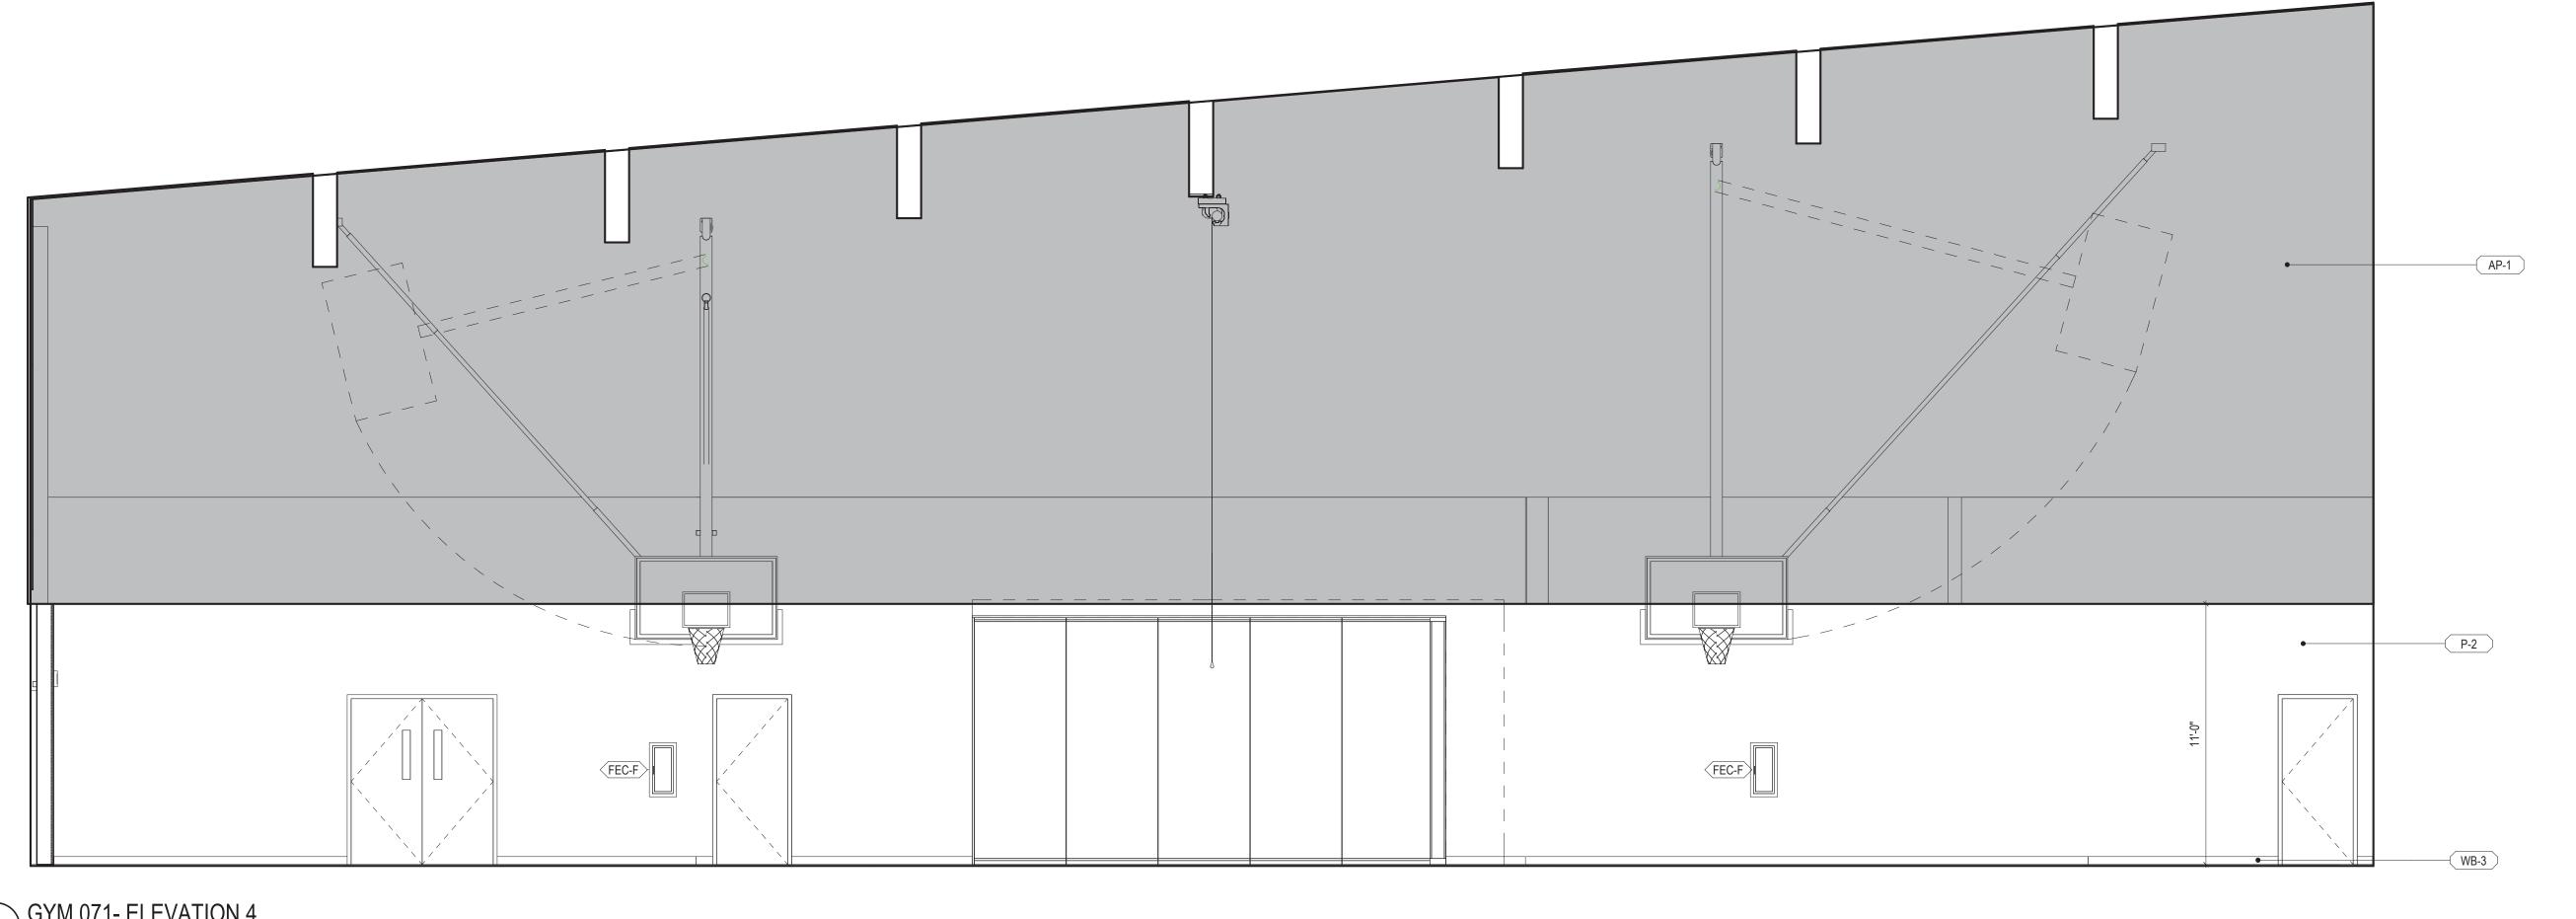

2 GYM 071- ELEVATION 4
1/4" = 1'-0"

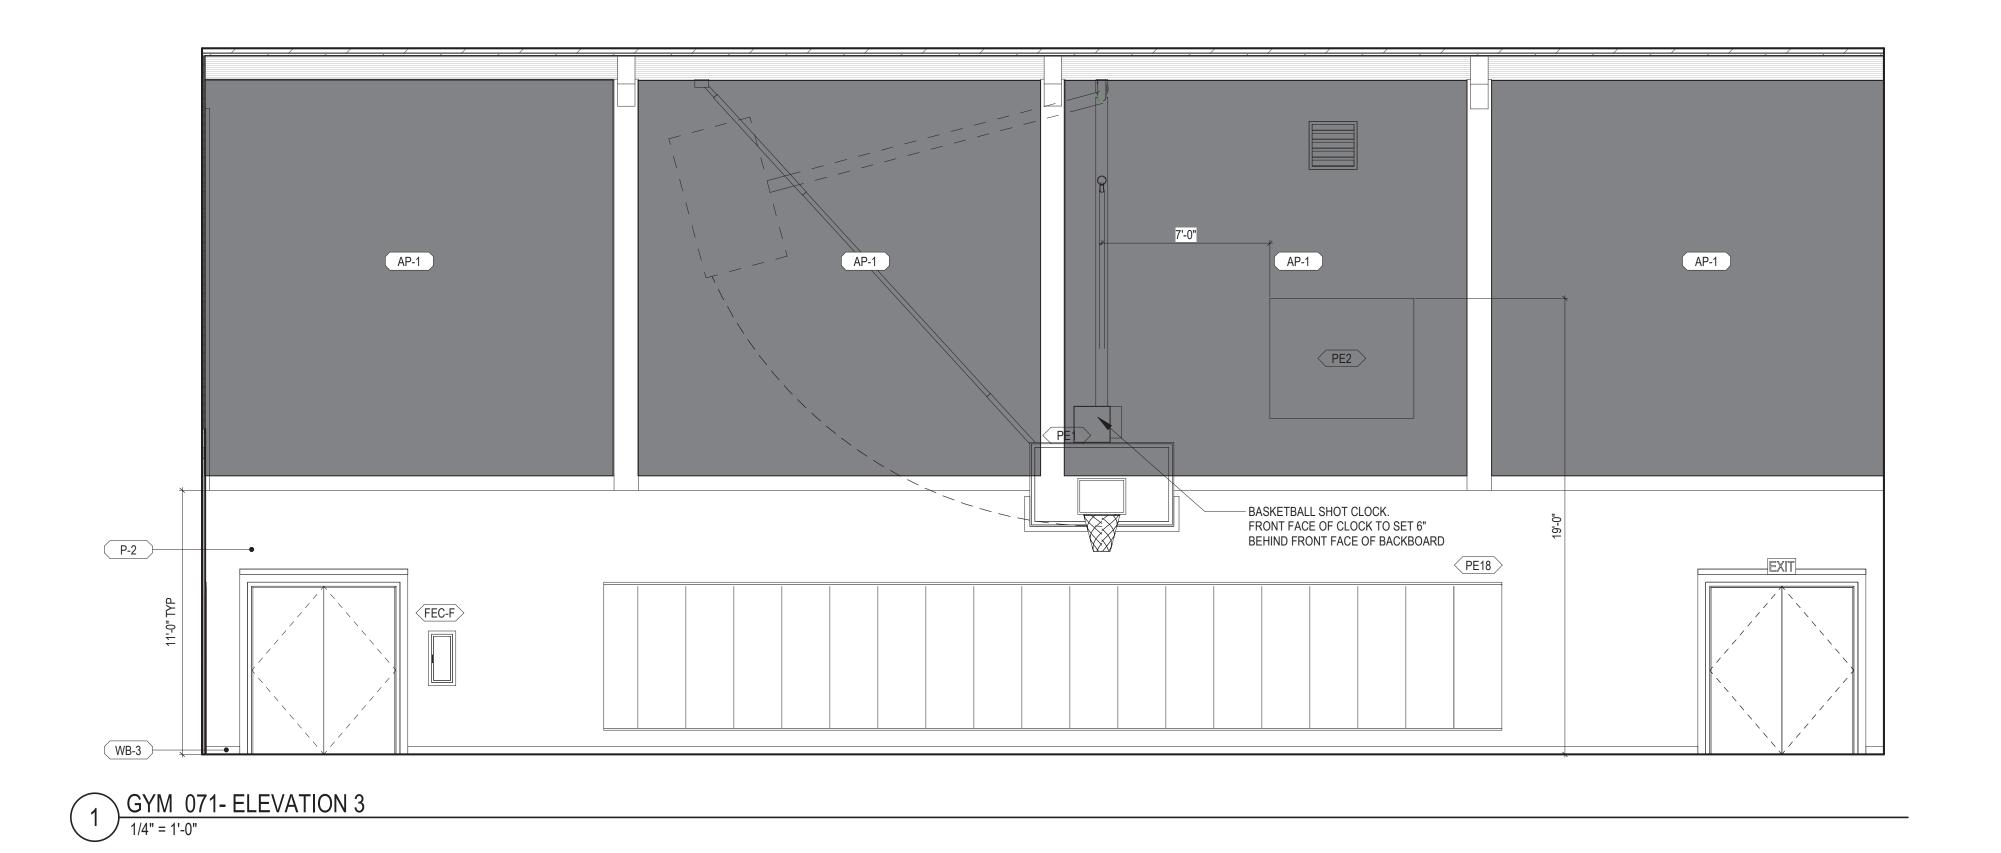

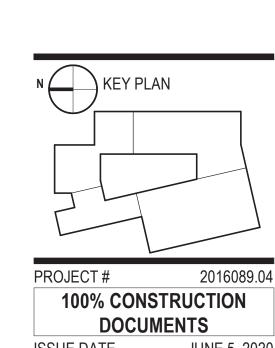

PROJECT # 2016089.04

100% CONSTRUCTION


DOCUMENTS

ISSUE DATE JUNE 5, 2020

REVISION SCHEDULE

INTERIOR ELEVATIONS

A70.05

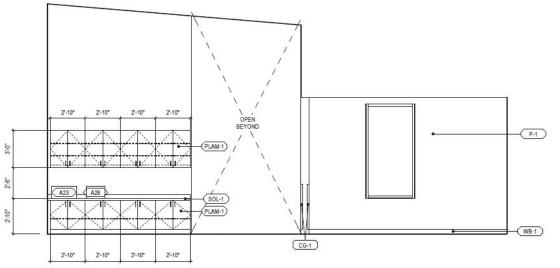

OFFICE 013 - ELEVATION 1
1/4" = 1'-0"